


**Figure 1:** Berkeley Landfill Location Map

SAN FRANCISCO BAY

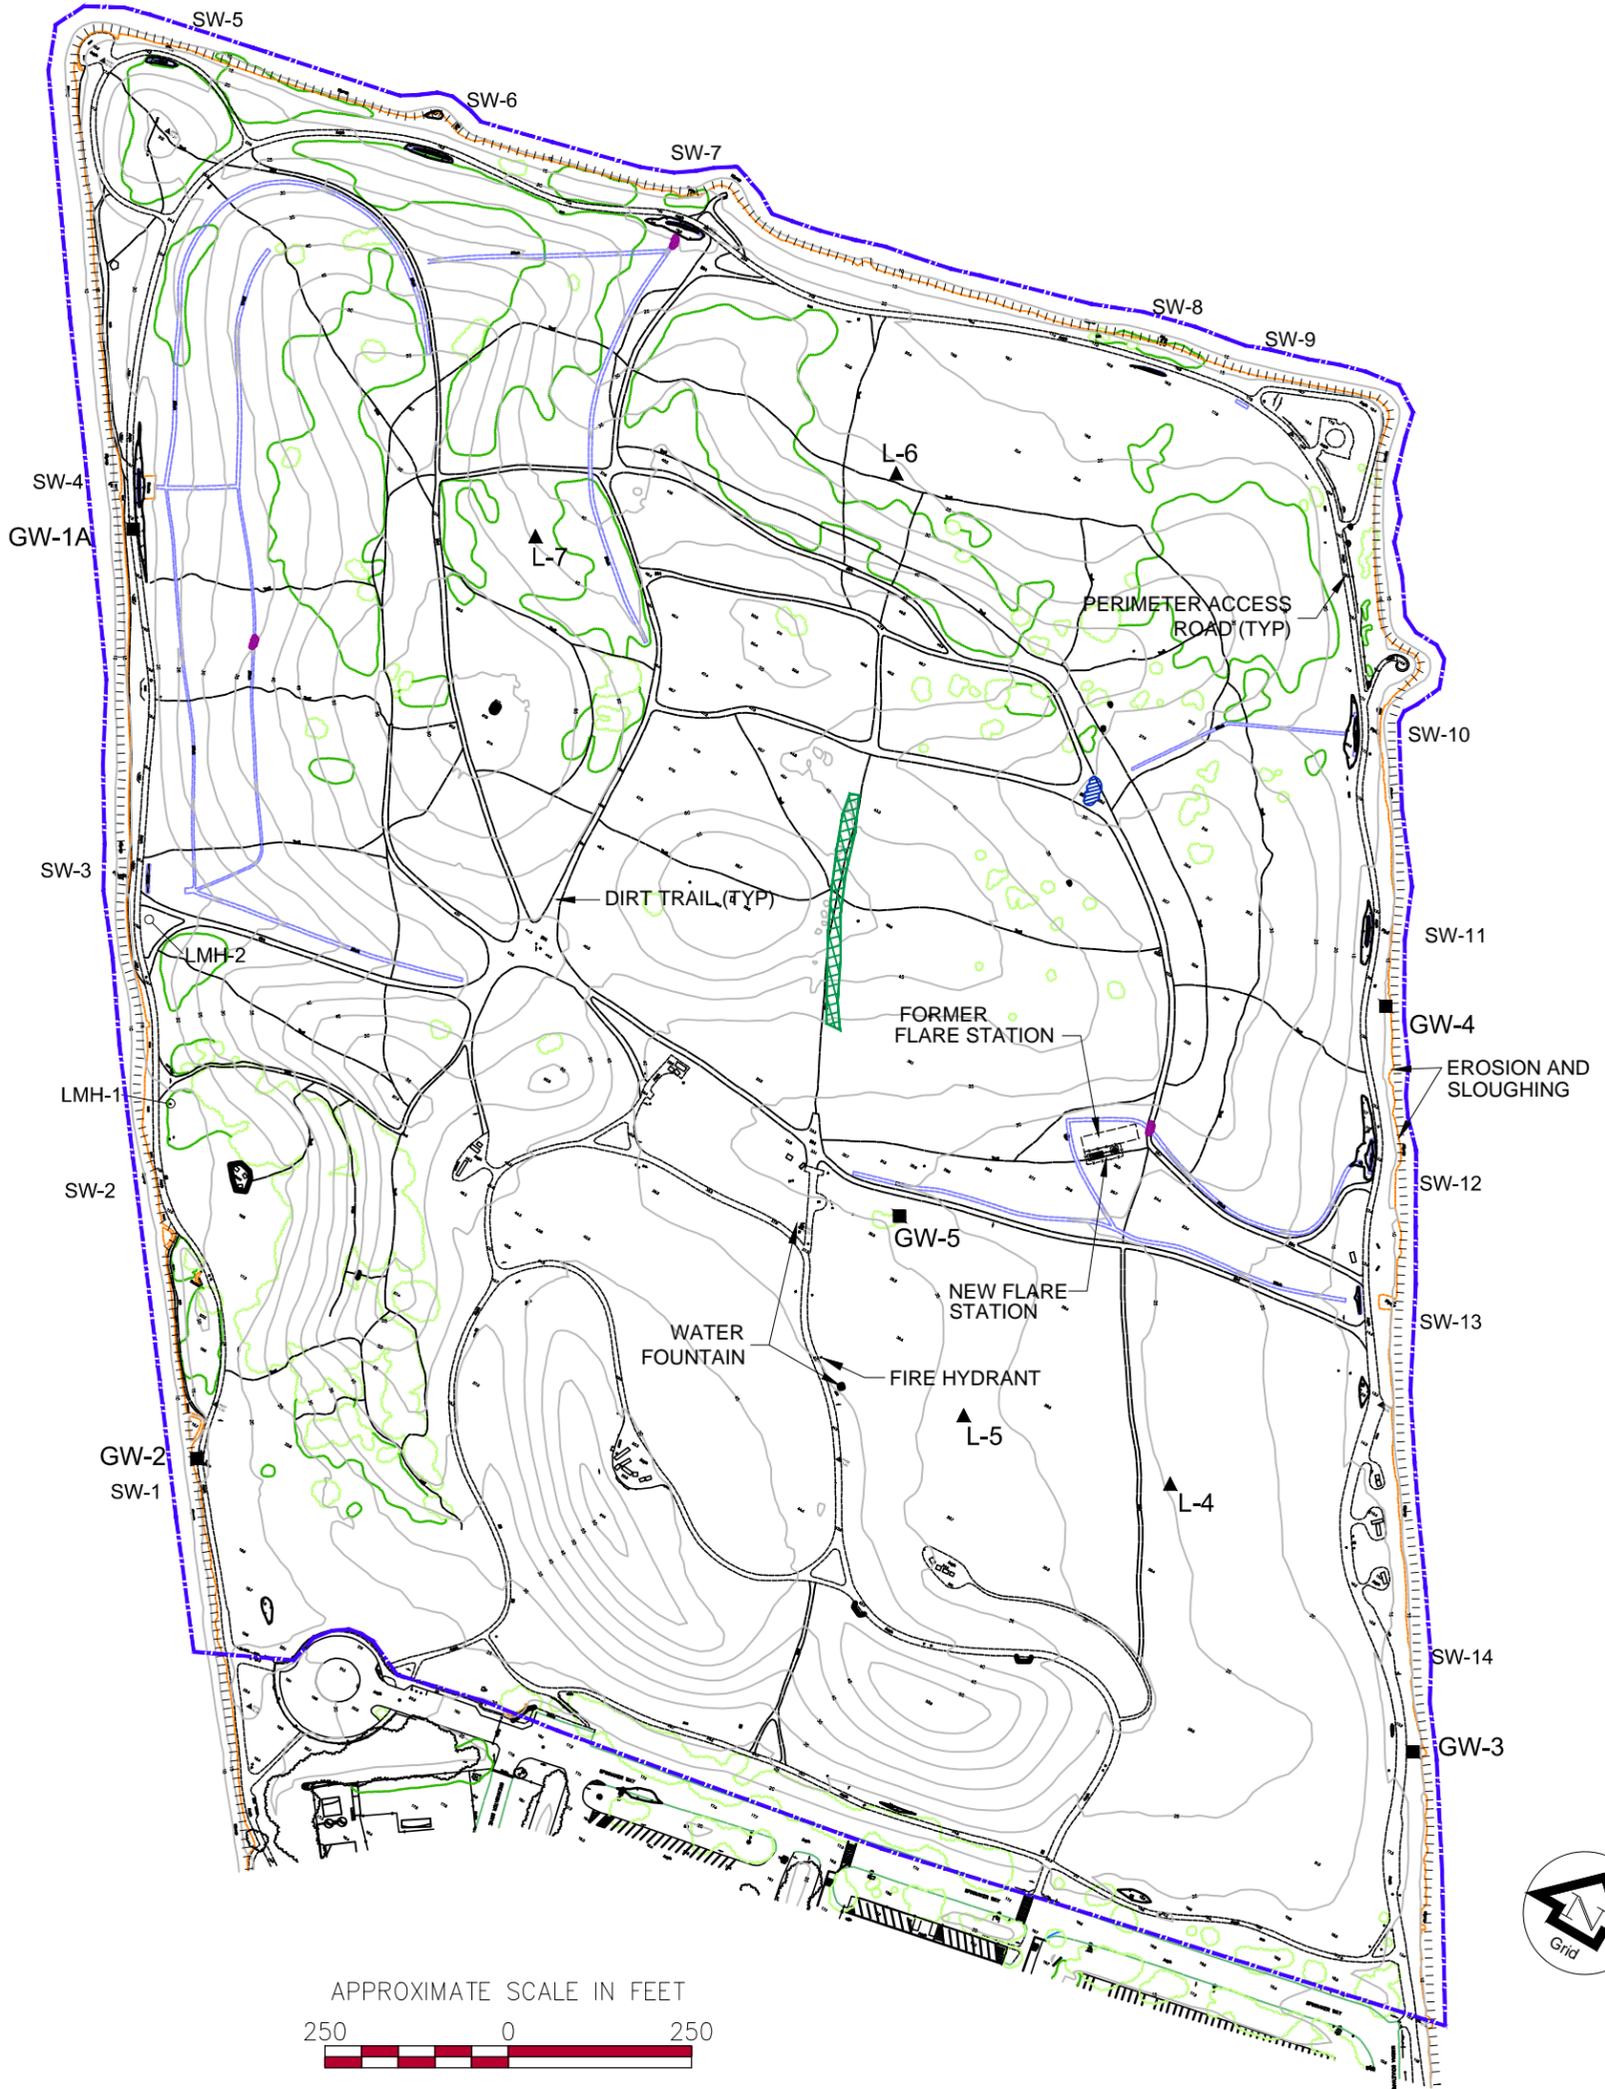

LEGEND

- SITE PERIMETER OBSERVATION LOCATION
- GROUNDWATER MONITORING WELL
- LEACHATE MONITORING WELL
- LIQUID COLLECTION SUMP
- RIP RAP ARMOR
- CONCRETE DRAINAGE DITCH (V-ditch)
- GENERAL SITE BOUNDARY
- PONDING WATER OR EVIDENCE OF PREVIOUS PONDING WATER
- EROSION OBSERVED
- SEDIMENT AND/OR DEBRIS (VEGETATIVE OR NON-LANDFILL IN ORIGIN)
- WOOD MULCHED AREA

**SCS ENGINEERS**  
 ENVIRONMENTAL CONSULTANTS & CONTRACTORS  
 6601 KOLL CENTER PARKWAY, SUITE 140  
 PLEASANTON, CALIFORNIA 94566  
 PH. (925) 426-0080 FAX. (925) 426-0707

PROJ. NO. 01210112.01  
 DSN. BY: TMS

DWN. BY: TMS  
 CHK. BY: TMS

ACAD FILE: Fig 2 Site Plan.dwg  
 APP. BY: J. MILLER

ORIGINAL TOPOGRAPHY BY AERIAL METHODS 2015. AERIAL PHOTOGRAPHY PERFORMED ON SEPTEMBER 4, 2015. BASE PROVIDED BY:

**TOWILL** Surveying, Mapping and GIS Services

-VALUES ARE IN US SURVEY FOOT  
 -HORIZONTAL CONTROL IN GROUND VALUES USING AN ASSUMED ORIGIN  
 -VERTICAL CONTROL IN MLLW DATUM  
 THE CONTROL TABLE VALUES CONTAINED HEREIN HAVE BEEN REVIEWED BY ME OR UNDER MY DIRECTION FOR CONFORMITY WITH RECORD INFORMATION ONLY.  
 Randy Smith, PLS 7198


SHEET TITLE: SITE PLAN

PROJECT TITLE: CLOSED BERKELEY LANDFILL  
 CITY OF BERKELEY


DATE: 8/31/2016

SCALE: AS SHOWN

FIGURE NO. 2

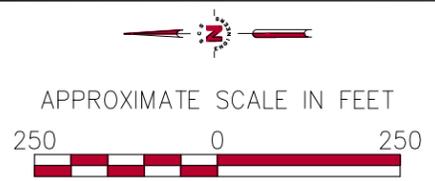

APPROXIMATE LIMITS OF BERKELEY LANDFILL  
(FACILITY NO. 01-AC-0001)

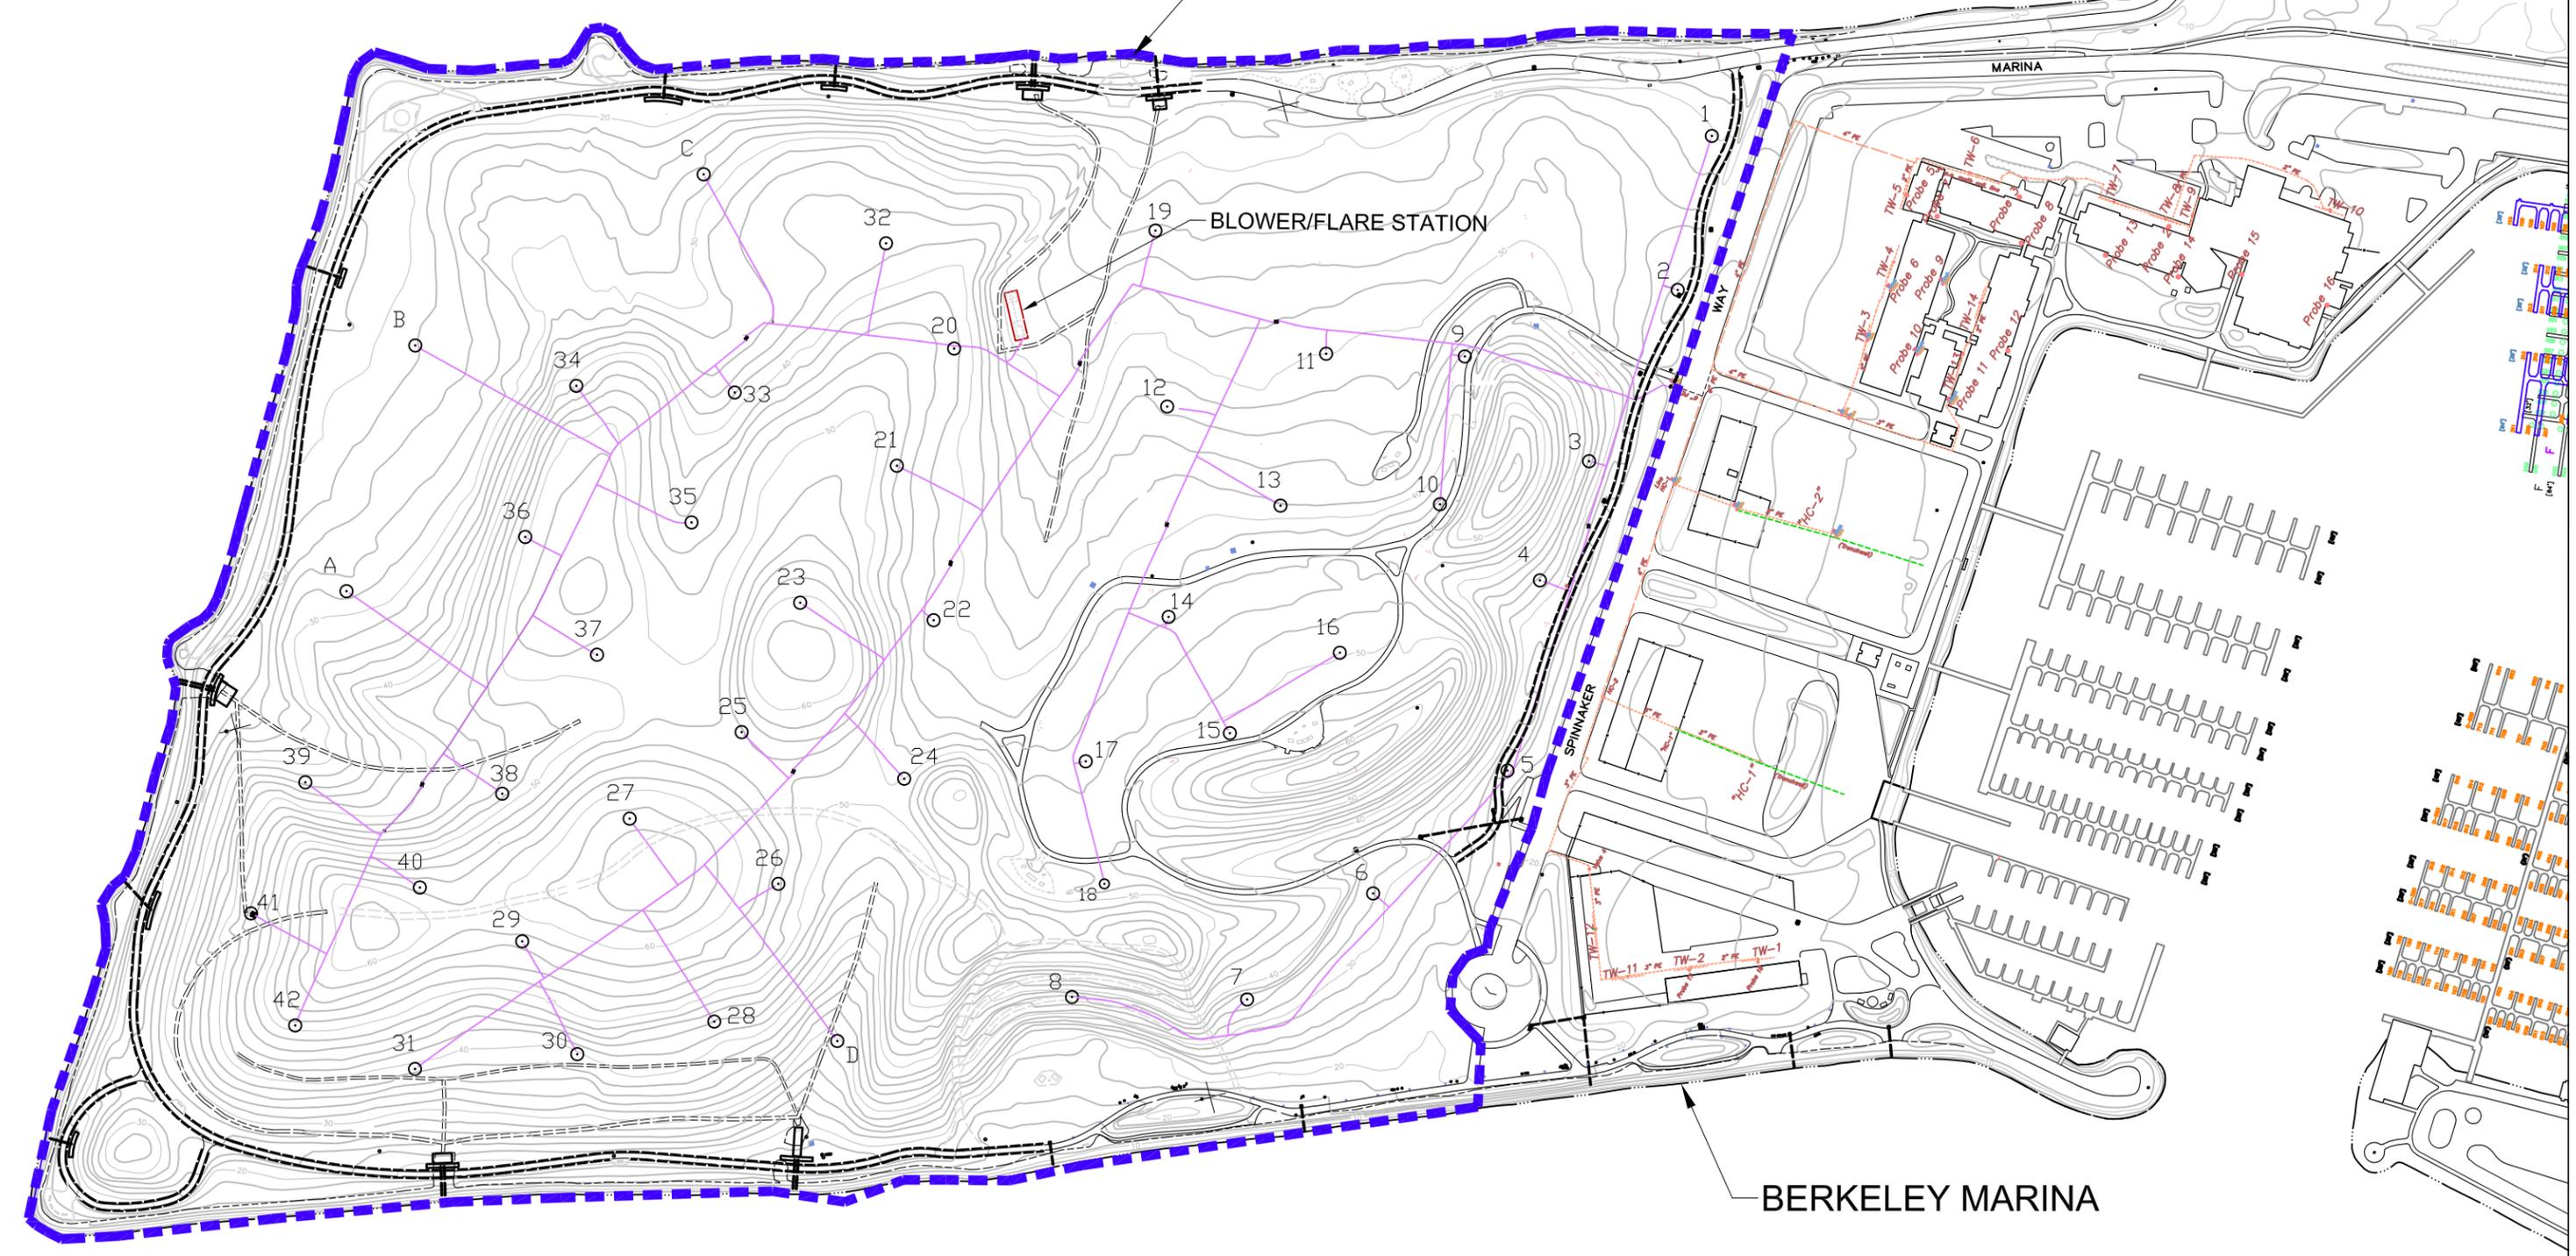

LEGEND

-  GAS COLLECTION HEADER (BELOW GRADE)
-  VERTICAL GAS EXTRACTION WELL
-  TW-4 HORIZONTAL TRENCH WELL (MARINA PROPERTY)
-  HC-1 HORIZONTAL COLLECTOR PIPE (MARINA PROPERTY)
-  Probe 5 LFG MONITORING WELL (MARINA PROPERTY)

**SCS ENGINEERS**  
Environmental Consultants and Contractors  
6601 Koll Center Parkway, Suite 140  
Pleasanton, California 94566  
(925) 426-0080 FAX: (925) 426-0707

PROJ. NO. 07194062.00	DWN. BY: HLG	ACAD FILE: Figure1 LFG Control System.dwg
DSN. BY: JJM	CHK. BY: JJM	APP. BY: J. MILLER

NOTE:  
ORIGINAL TOPOGRAPHY BY AERIAL METHODS  
1992. BASE MAP PROVIDED BY CITY OF  
BERKELEY.

SHEET TITLE:  
**LANDFILL GAS CONTROL SYSTEM**


PROJECT TITLE:  
**BERKELEY LANDFILL  
CITY OF BERKELEY**

NO.	REVISION	DATE

DATE:  
3/30/09


SCALE:  
AS SHOWN

FIGURE NO.  
**1**

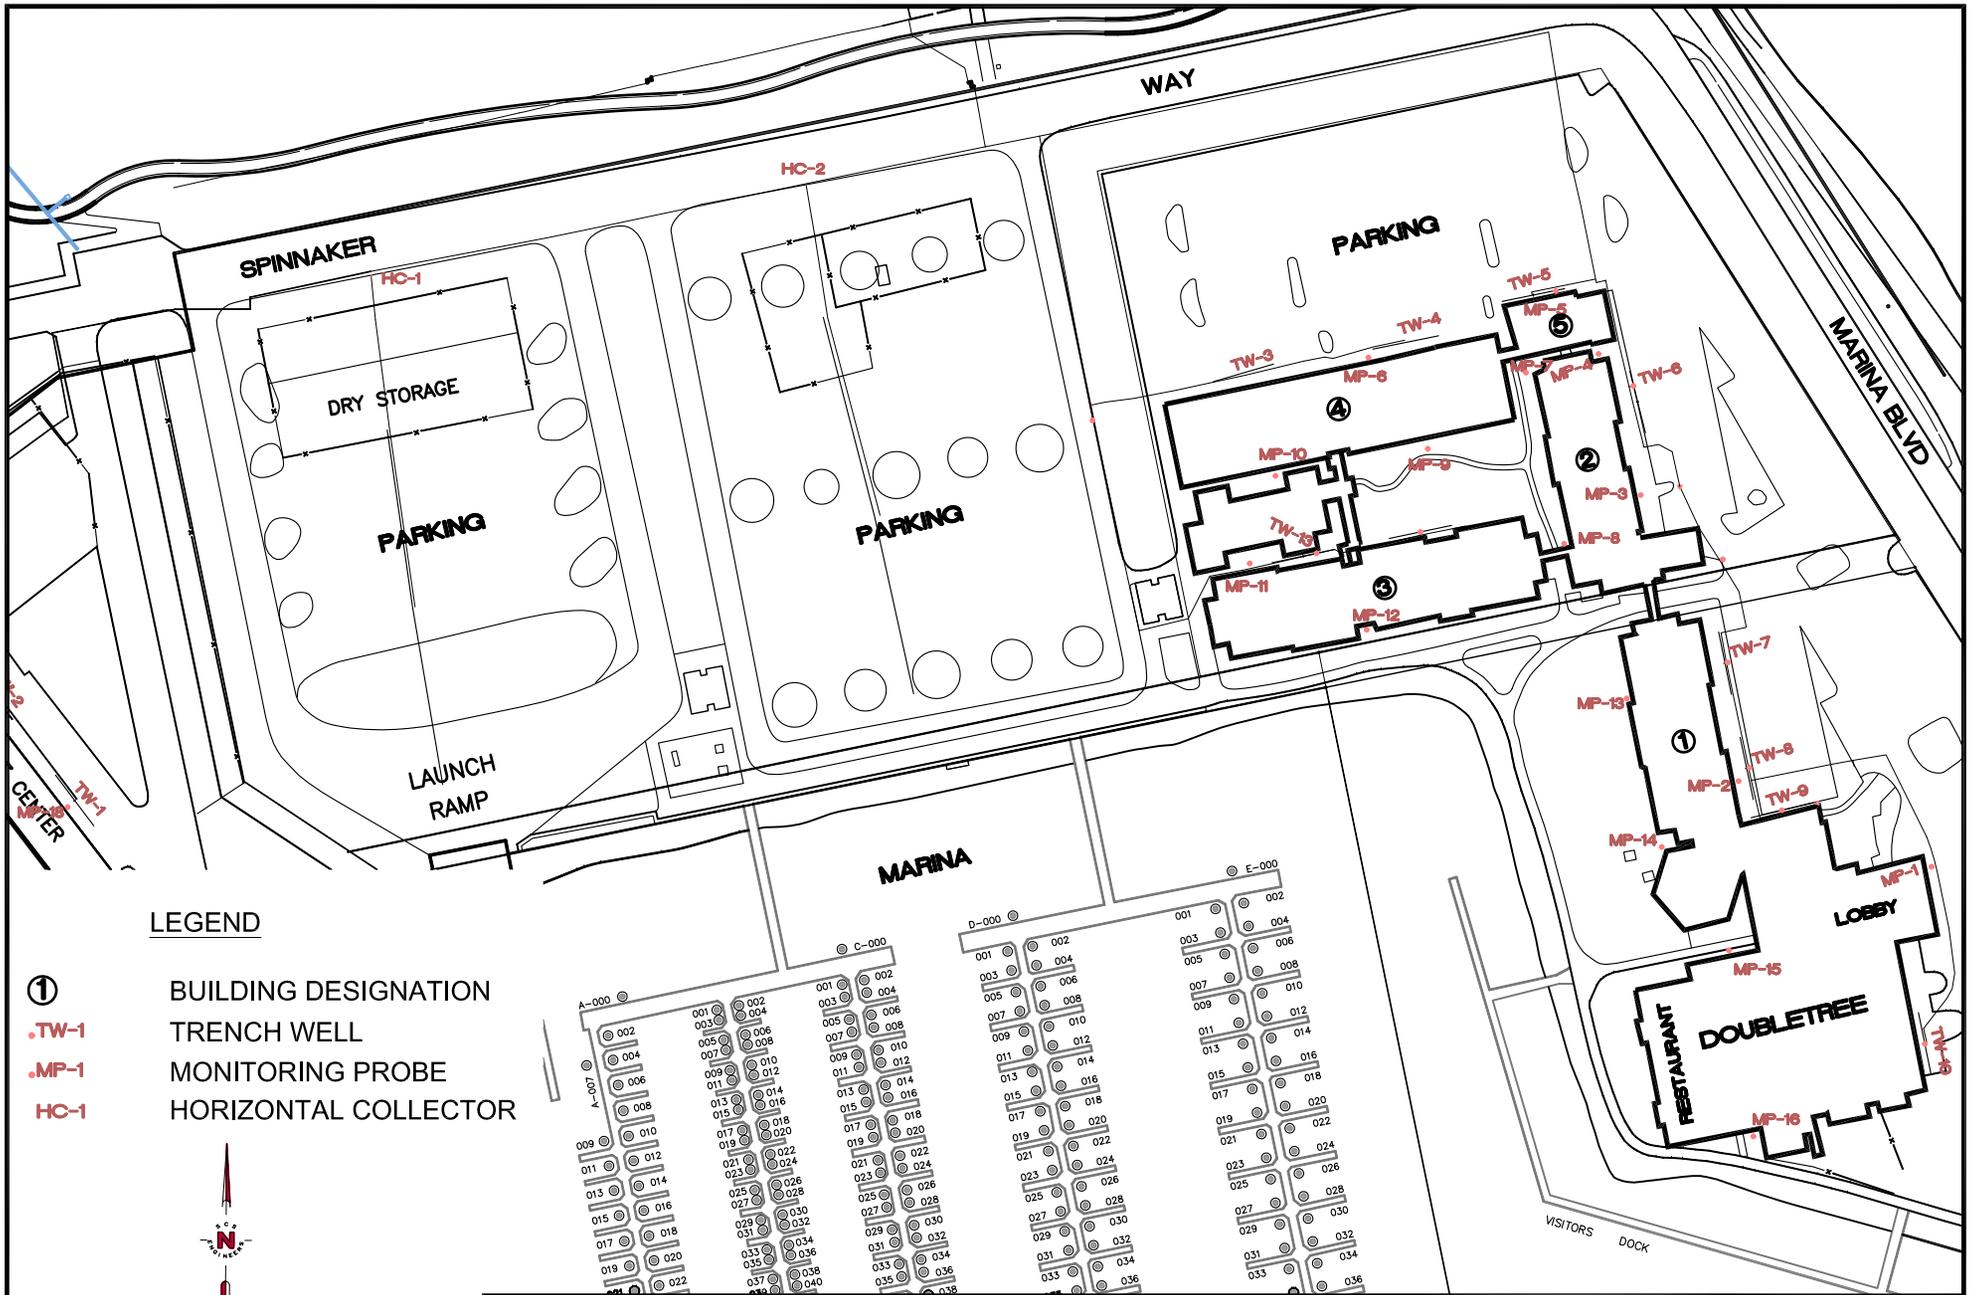

**LEGEND**

- ① BUILDING DESIGNATION
- .TW-1 TRENCH WELL
- .MP-1 MONITORING PROBE
- HC-1 HORIZONTAL COLLECTOR

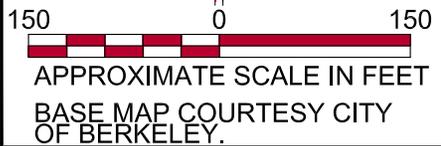

**SCS ENGINEERS**  
 ENVIRONMENTAL CONSULTANTS  
 6601 KOLL CENTER PARKWAY, SUITE 140  
 PLEASANTON, CALIFORNIA 94566  
 PHONE: (925) 426-0080 FAX.: (925) 426-0707

**HOTEL SITE PLAN**  
 DOUBLETREE HOTEL  
 BERKELEY MARINA LANDFILL  
 BERKELEY, CALIFORNIA

SCALE: AS SHOWN  
 PROJECT NO. 07194062.00  
 DATE: 6-25-08

FIGURE NO.  
**2**